
PROPOSED FIRST FLOOR Drainage Layout FLAT A

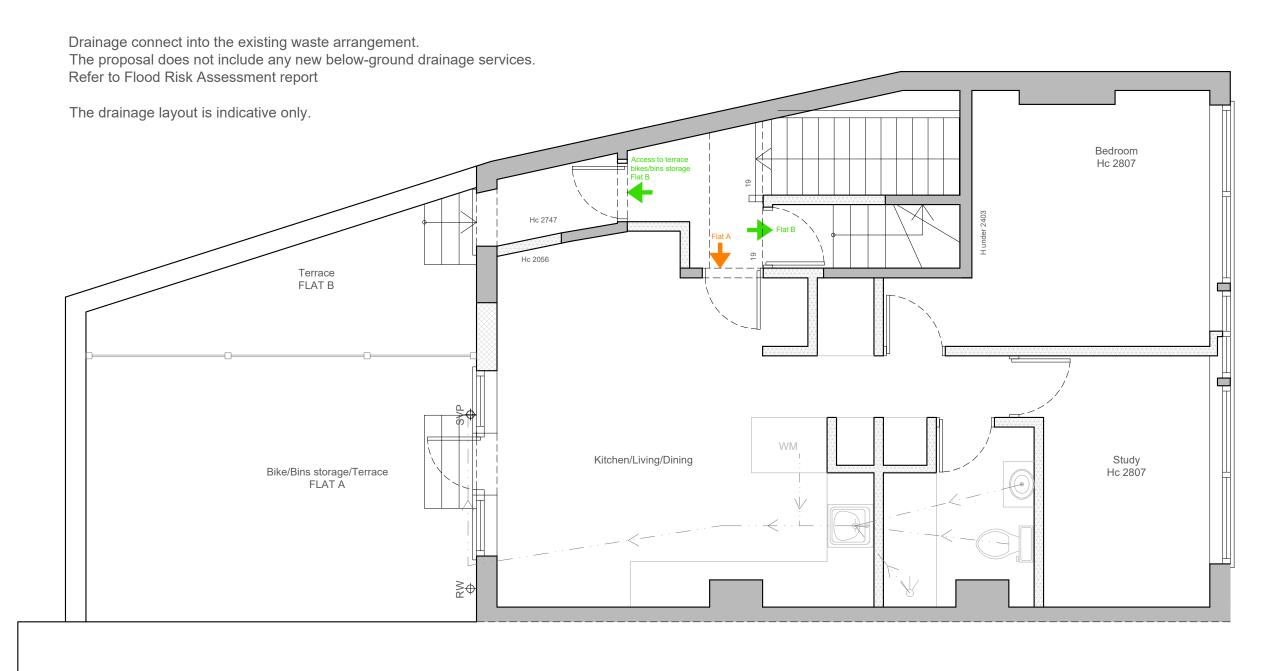

Drawn by: MG



Architecture



12 High St, Hampton Wick, Kingston upon Thames KT1 4DB T: 0845 519 4321

THE DESIGN OF THIS DRAWING IS COPYRIGHT AND REMAINS THE PROPERTY
OF ARCHITECTURE 100 - CITY LOFTS LONDON

ALL WORK TO COMPLY WITH
CURRENT BUILDING REGULATIONS
AND CODE OF PRACTICE
DO NOT SCALE FROM DRAWINGS
ALL DIMENSIONS TO BE CHECKED ON
SITE BEFORE THE START OF ANY

Project: 12 High Street, Hampton Wic Kingston upon Thames KT1 4DB
Client:

City Loft London

Drawing ID:
12A_HS-P.P.01

Drawing Description:

Proposed First Floor

Drainage-Layout

Drawn by: MG	Drawing Scale: 1:50 @ A3				Drawing P5.1	N
	+	-	-	-		-

DATE REV. 14.06.2024 DESCRIPTION Proposed Drawings