
PROPOSED SECOND FLOOR Drainage Layout FLAT B

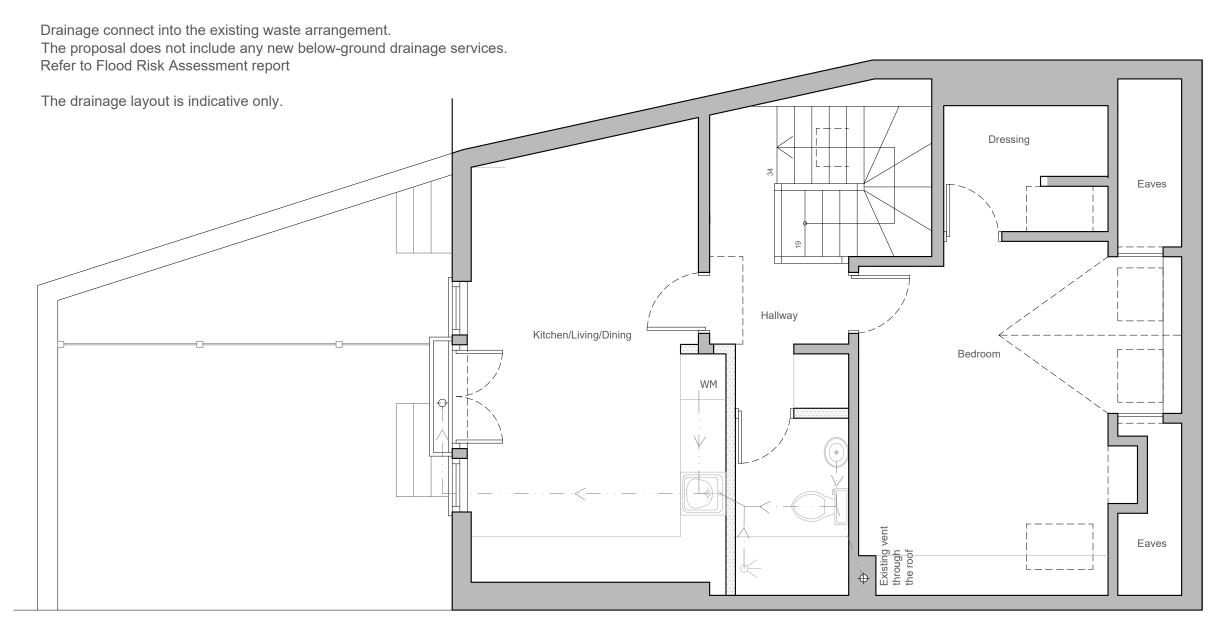



,	Architecture	
	100	



12 High St, Hampton Wick, Kingston upon

Thames KT1 4DB

T: 0845 519 4321

THE DESIGN OF THIS DRAWING IS COPYRIGHT AND REMAINS THE PROPERTY OF ARCHITECTURE 100 - CITY LOFTS LONDON

ALL WORK TO COMPLY WITH
CURRENT BUILDING REGULATIONS
AND CODE OF PRACTICE
DO NOT SCALE FROM DRAWINGS
ALL DIMENSIONS TO BE CHECKED ON
SITE BEFORE THE START OF ANY

Project: 12 High Street, Hampton Wick Kingston upon Thames KT1 4DB
Client:

City Loft London

Drawing ID:	
12A_HS-P.P.02	

Drawing Description:

Proposed Second Floor Drainage Layout

Drawing Scale: 1:50 @ A3 Drawn by: MG

Drawing Number P7.3

DATE REV. 14.06.2024 DESCRIPTION Proposed Drawings