
© Octopus Energy 2023

Accredited by: octopus energy services

<sup>Client/Project:</sup> Carol Sargent 87 ALBURY CLOSE,HAMPTON,MIDDLESEX TW12 3BB

Drawing title: Site plan as existing

Project status: PLANNING

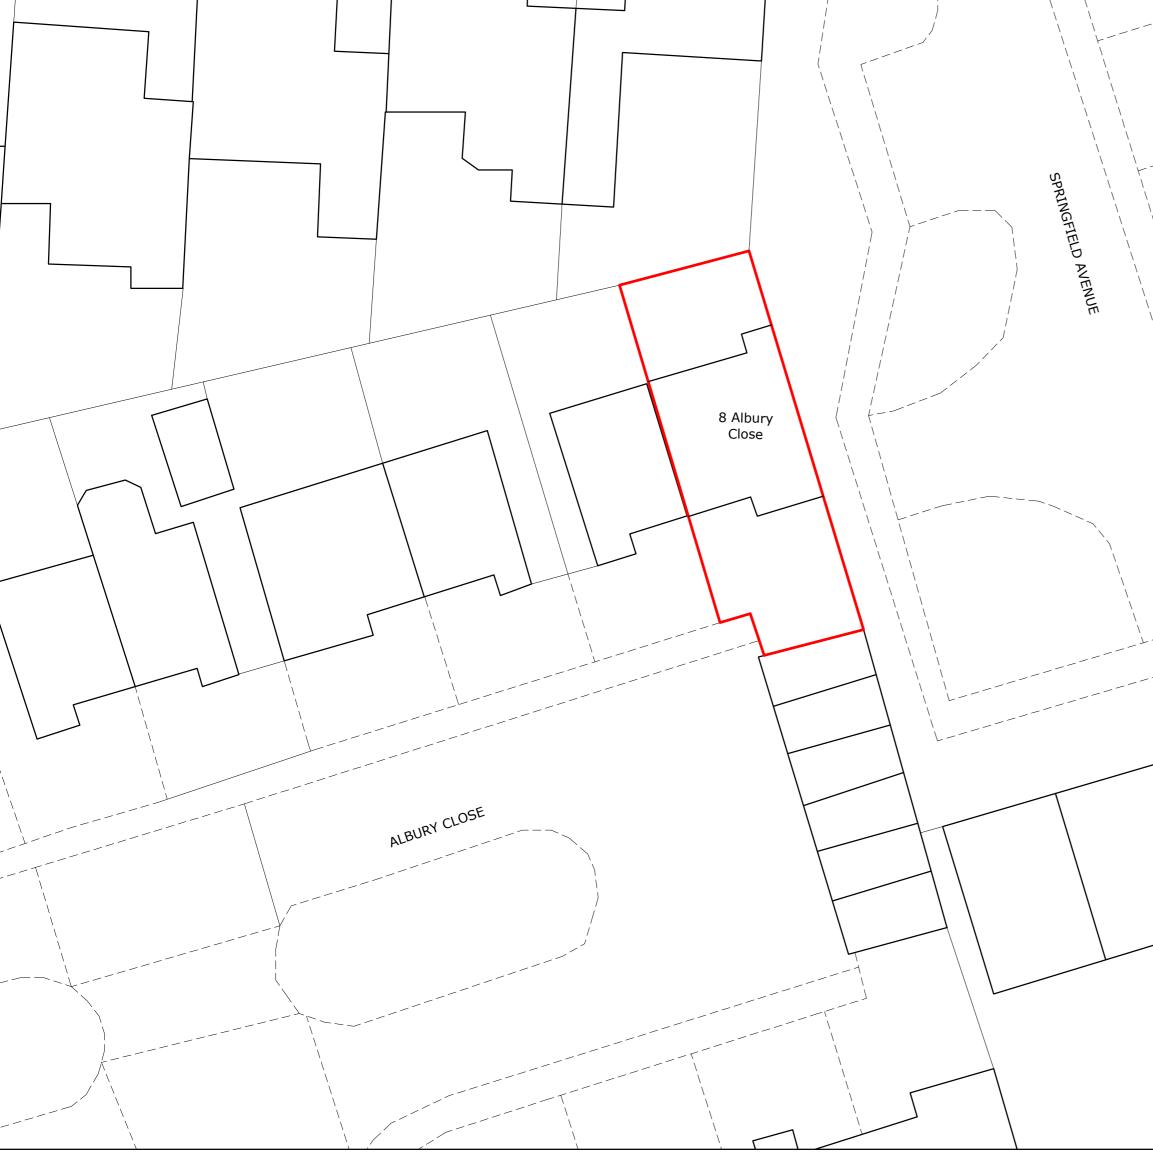

			n	
	Scale: 1:200	Paper Size: A2	Drawn: T. Siddiqui	Checked:

				 1.2
	Description: Installation of 1No air source heat pump to the rear			Pro
ev:	Description:	By:	Date:	J-8/

Scale:	Paper Size:	Drawn:	Checked:
1:200	A2	T. Siddiqui	
Project ID:	Drawing No:	Revision:	Date:
J-8A849C5F	01	-	16.09.2024